

LEGEND:-

— (Red dashed line) — PRESENT SCOPE

— (Solid line) — FUTURE / EXISTING SCOPE

↔ EXISTING/FUTURE


POWER GRID CORPORATION OF INDIA LIMITED
 (A Government of India Enterprise)

PROJECT:
 TRANSMISSION SYSTEM FOR EVACUATION OF POWER FROM
 RAJASTHAN REZ PH-IV (PART-2: 5.5 GW) (JAISALMER/
 BARMER COMPLEX): PART C

TITLE: BAY ALLOCATION AT 765KV INDORE S/S FOR TERMINATION
 OF INDORE-AHMEDABAD 765KV D/C LINE-SINGLE LINE DIAGRAM

DGM (ENGG-S/S)	CGM (ENGG-S/S)	ED (ENGG-SS,TL,CVL)
CLEARED BY		APPROVED BY

DRAWN PRASOON	DRAWING NO. C/ENGG/TBCB/KHAWDA/INDORE-X/SLD	REV. 0
------------------	--	-----------

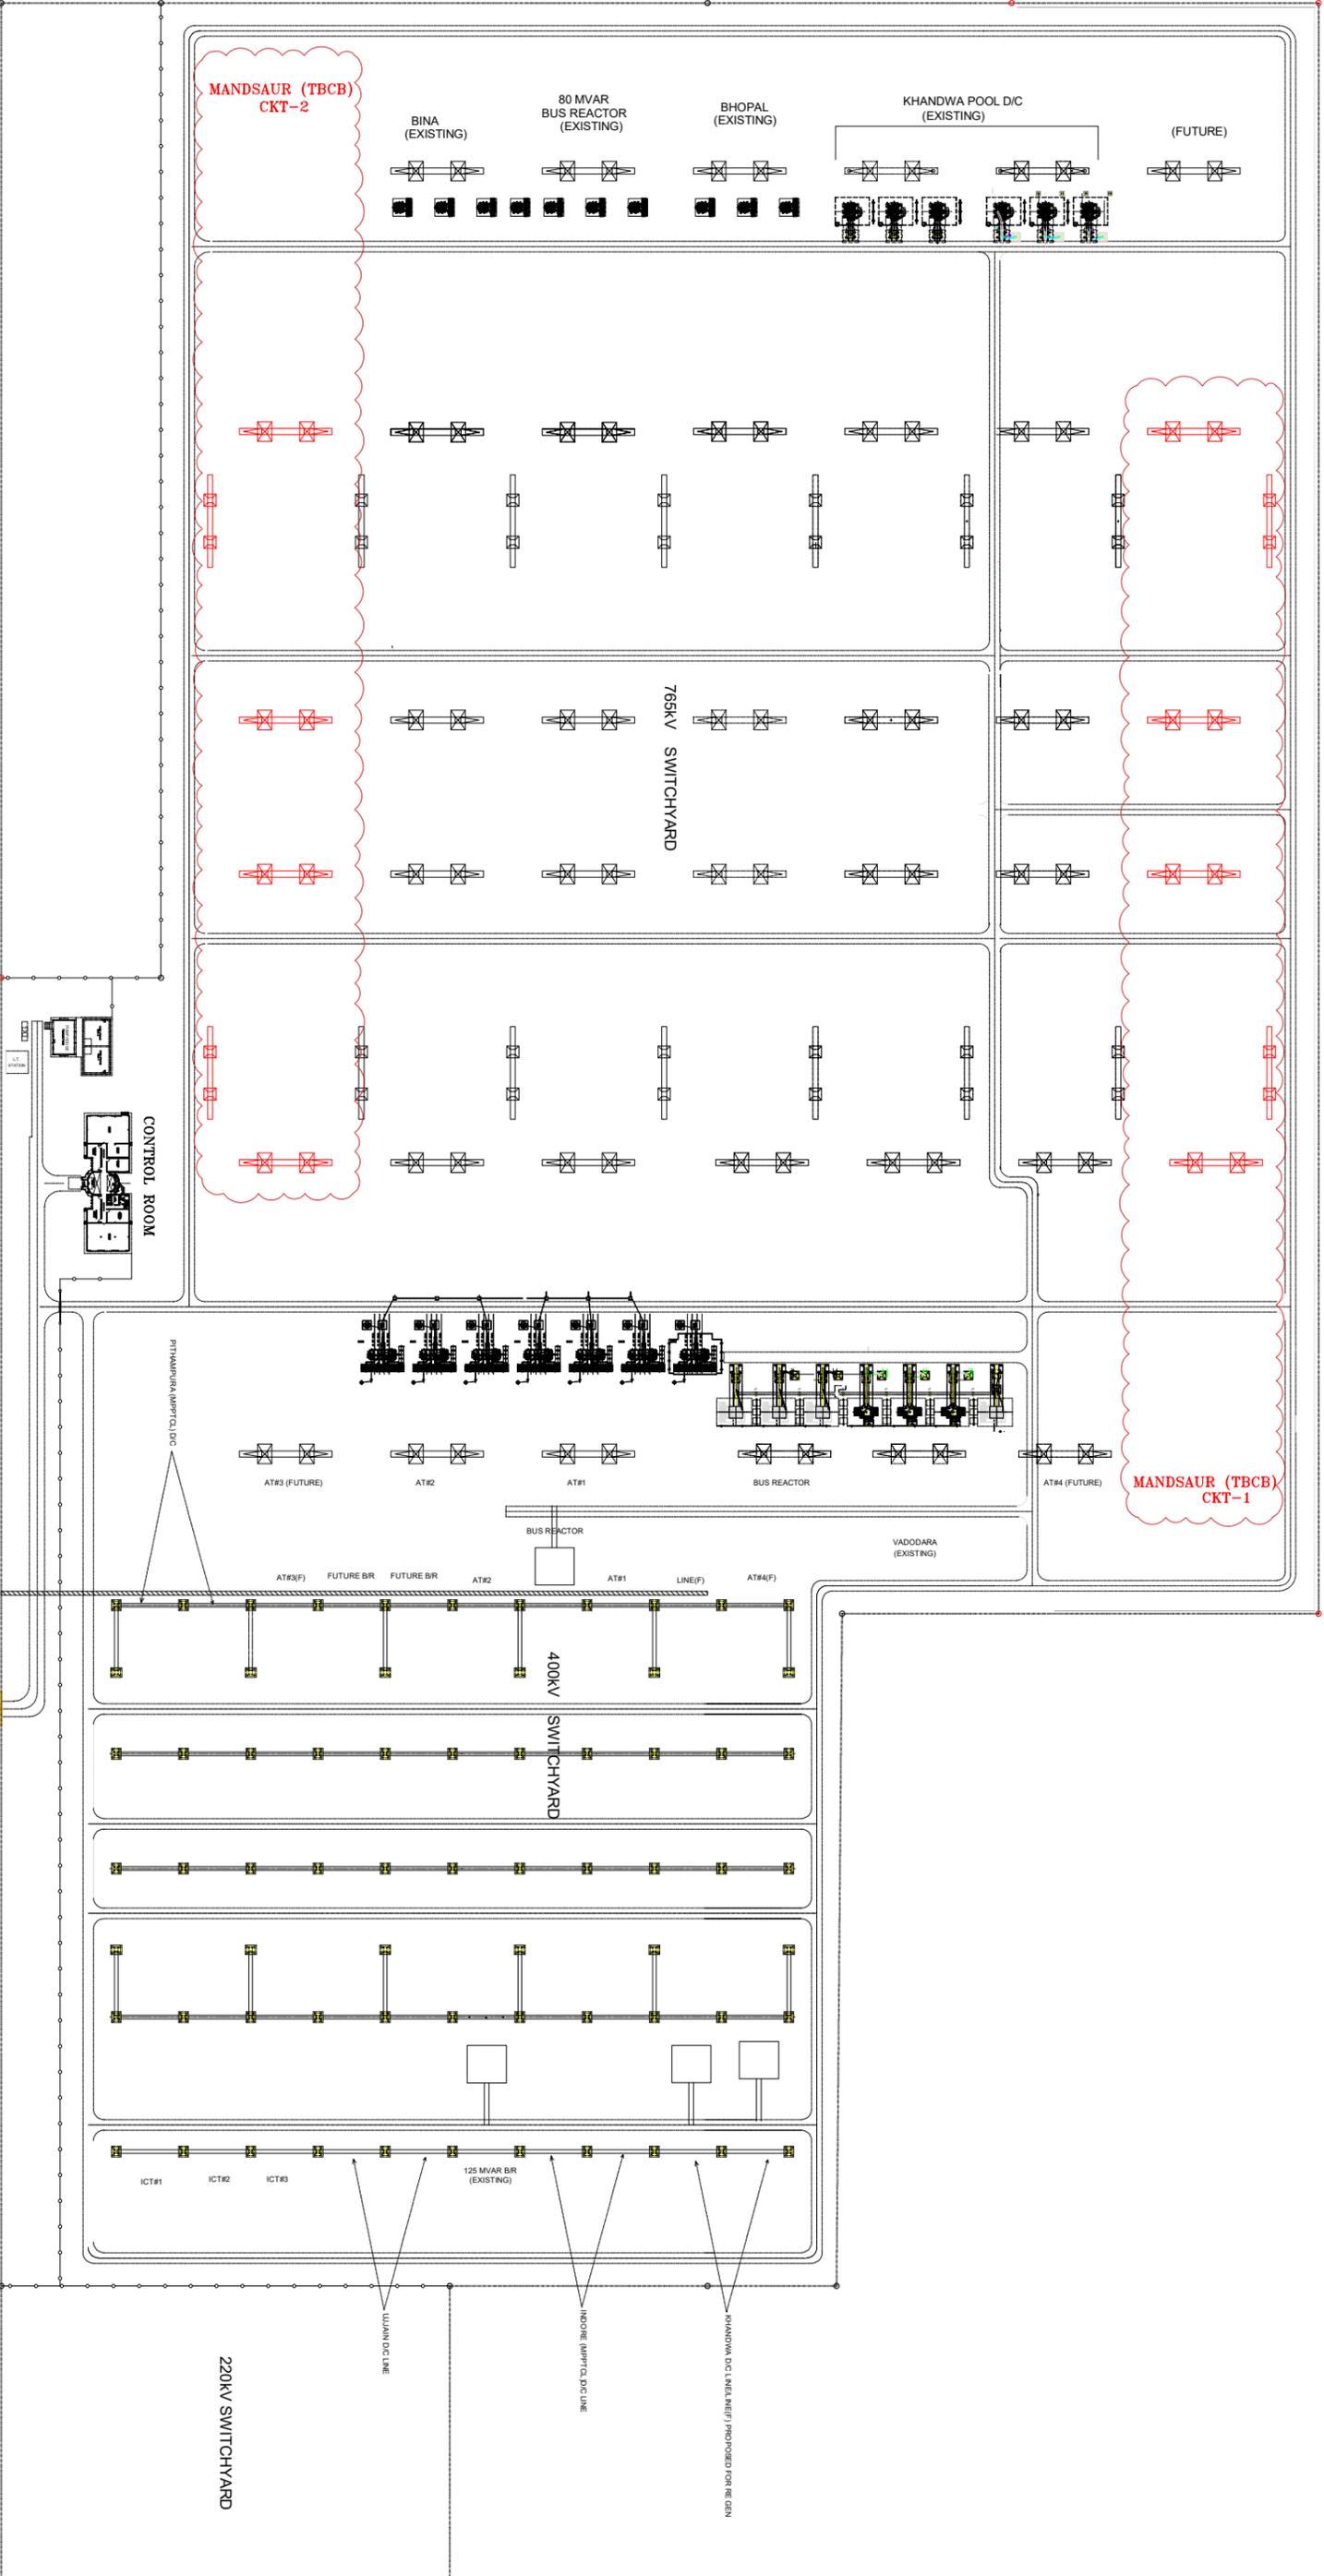

FUTURE/EXISTING
 PRESENT SCOPE UNDER TRANSMISSION SCHEME FOR TRANSMISSION SYSTEM
 FOR EVACUATION OF POWER FROM RAJASTHAN REZ PH-IV (PART-2):
 5.5 GW (JAISALMER/BARMER COMPLEX): PART C

DGM (ENGG-S/S)	CHIEF GM (ENGG-S/S)	ED (ENGG-S/S, T/L & CIVIL)
CLEARED BY	APPROVED BY	

POWER GRID CORPORATION OF INDIA LIMITED

(A GOVERNMENT OF INDIA ENTERPRISE)

PROJECT: TRANSMISSION SYSTEM FOR EVACUATION OF POWER FROM RAJASTHAN REZ PH-IV (PART-2: 5.5 GW) (JAISALMER/BARMER COMPLEX): PART C
SUBSTATION: 765/400/220KV INDORE SUBSTATION

TITLE: BAY ALLOCATION AT 765KV INDORE S/S FOR TERMINATION OF INDORE-MANDSAUR PS 765KV D/C LINE-GENERAL ARRANGEMENT	DATE: OCT 2026
DRWN: PRASTVITI	DRG.NO.: C/ENGG-SS/TBCB/Bay Allocation/INDORE/GA
REV: 00	